

- NOTES**
- THIS DRAWING IS TO BE READ IN CONJUNCTION WITH ALL RELEVANT ARCHITECTURAL & STRUCTURAL DRAWINGS.
  - THIS DRAWING IS TO BE READ IN CONJUNCTION WITH ALL RELEVANT BUILDING SERVICES DRAWINGS & THE RELEVANT SECTIONS OF THE SPECIFICATIONS & SCHEDULES.
  - THIS DRAWING IS NOT TO BE SCALED.
  - ALL DIMENSIONS ARE IN mm UNLESS OTHERWISE STATED.

HEATING LEGEND	
COLOUR	DESCRIPTION
	LTHW SECONDARY FLOW
	LTHW SECONDARY RETURN


VENTILATION LEGEND	
COLOUR	DESCRIPTION
	FRESH AIR INTAKE
	EXHAUST AIR
	GENERAL SUPPLY
	GENERAL EXTRACT

DRAINAGE LEGEND	
COLOUR	DESCRIPTION
	SOIL VENT PIPE

ELECTRICAL EQUIPMENT LEGEND	
COLOUR	DESCRIPTION
	SOLAR PANEL
	SWITCH ISOLATOR SINGLE PHASE
	ODU DENOTES OUTDOOR UNIT
	KSF DENOTES KITCHEN SUPPLY FAN
	KEF DENOTES KITCHEN EXTRACT FAN

CONTAINMENT LEGEND	
COLOUR	DESCRIPTION
	PV HEAVY DUTY CONTAINMENT

FIRE ALARM LEGEND	
SYMBOL	DESCRIPTION
☠	SMOKE DETECTOR SOUNDER & BEACON
●	MANUAL CALL POINT
[I/U]	INTERFACE UNIT KSF DENOTES KITCHEN SUPPLY FAN

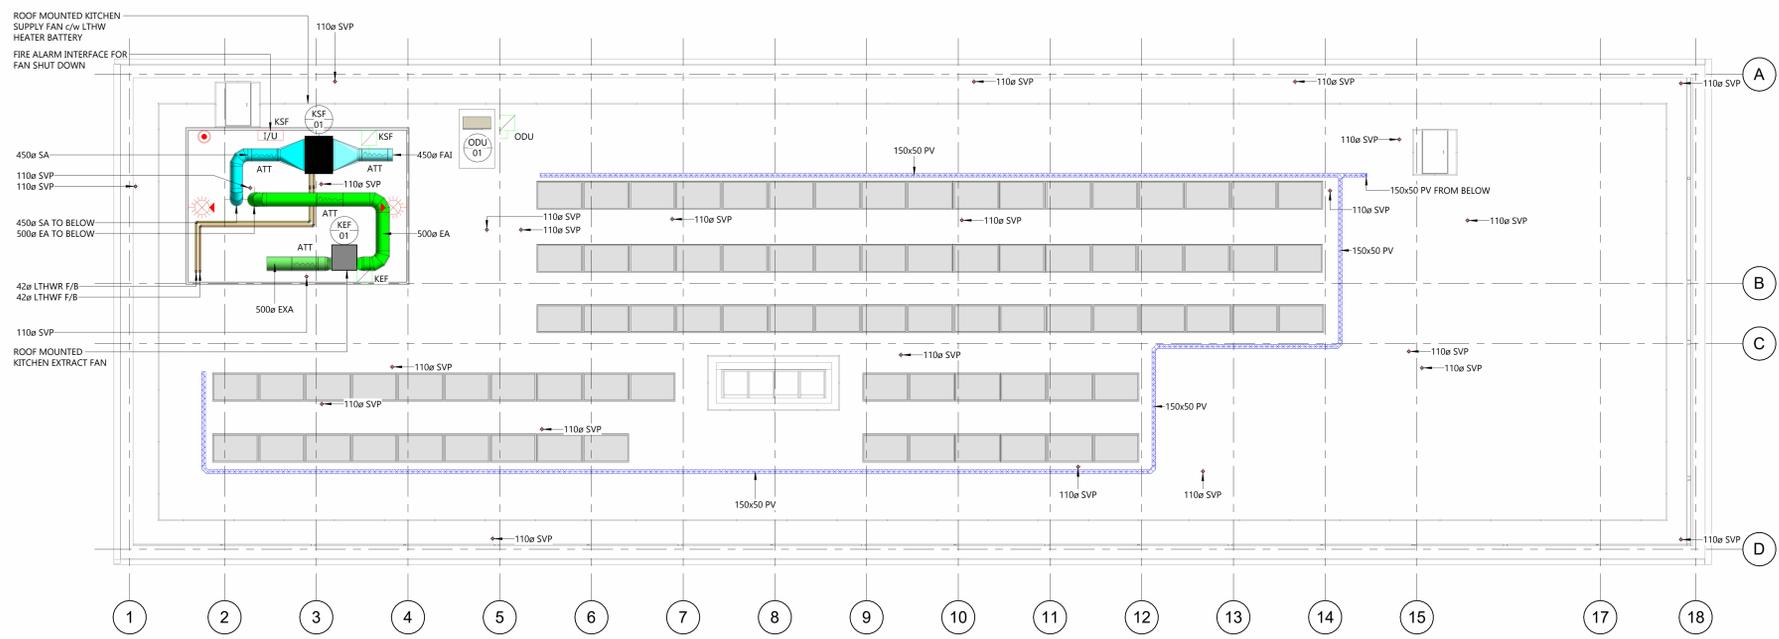

**1 MEP PLANT ROOF SERVICES LAYOUT**  
 1: 100

REV	DATE	DESCRIPTION	BY
P01	16.02.2026	STAGE 3 ISSUE	RL

**design MEP**  
 23 Rawson Street  
 Leicester, LE1 5JF  
 Email: Technical@designmep.co.uk

**Client:**  
**GallifordTry**  
 Project:  
 Bexley Road TLC

**Drawing Title:**  
 COMBINED SERVICES  
 MEP PLANT ROOF SERVICES LAYOUT

**Status:** FOR STAGE APPROVAL      **Suitability:** S3

**Drawing No:** BTLC-MEP-XX-RF-DR-ME-0702      **Rev:** P01

**Scale at A0:** 1:100      **Designed by:** RK      **Design check:** JOG  
**Drawn by:** RL      **BIM check:** GL